



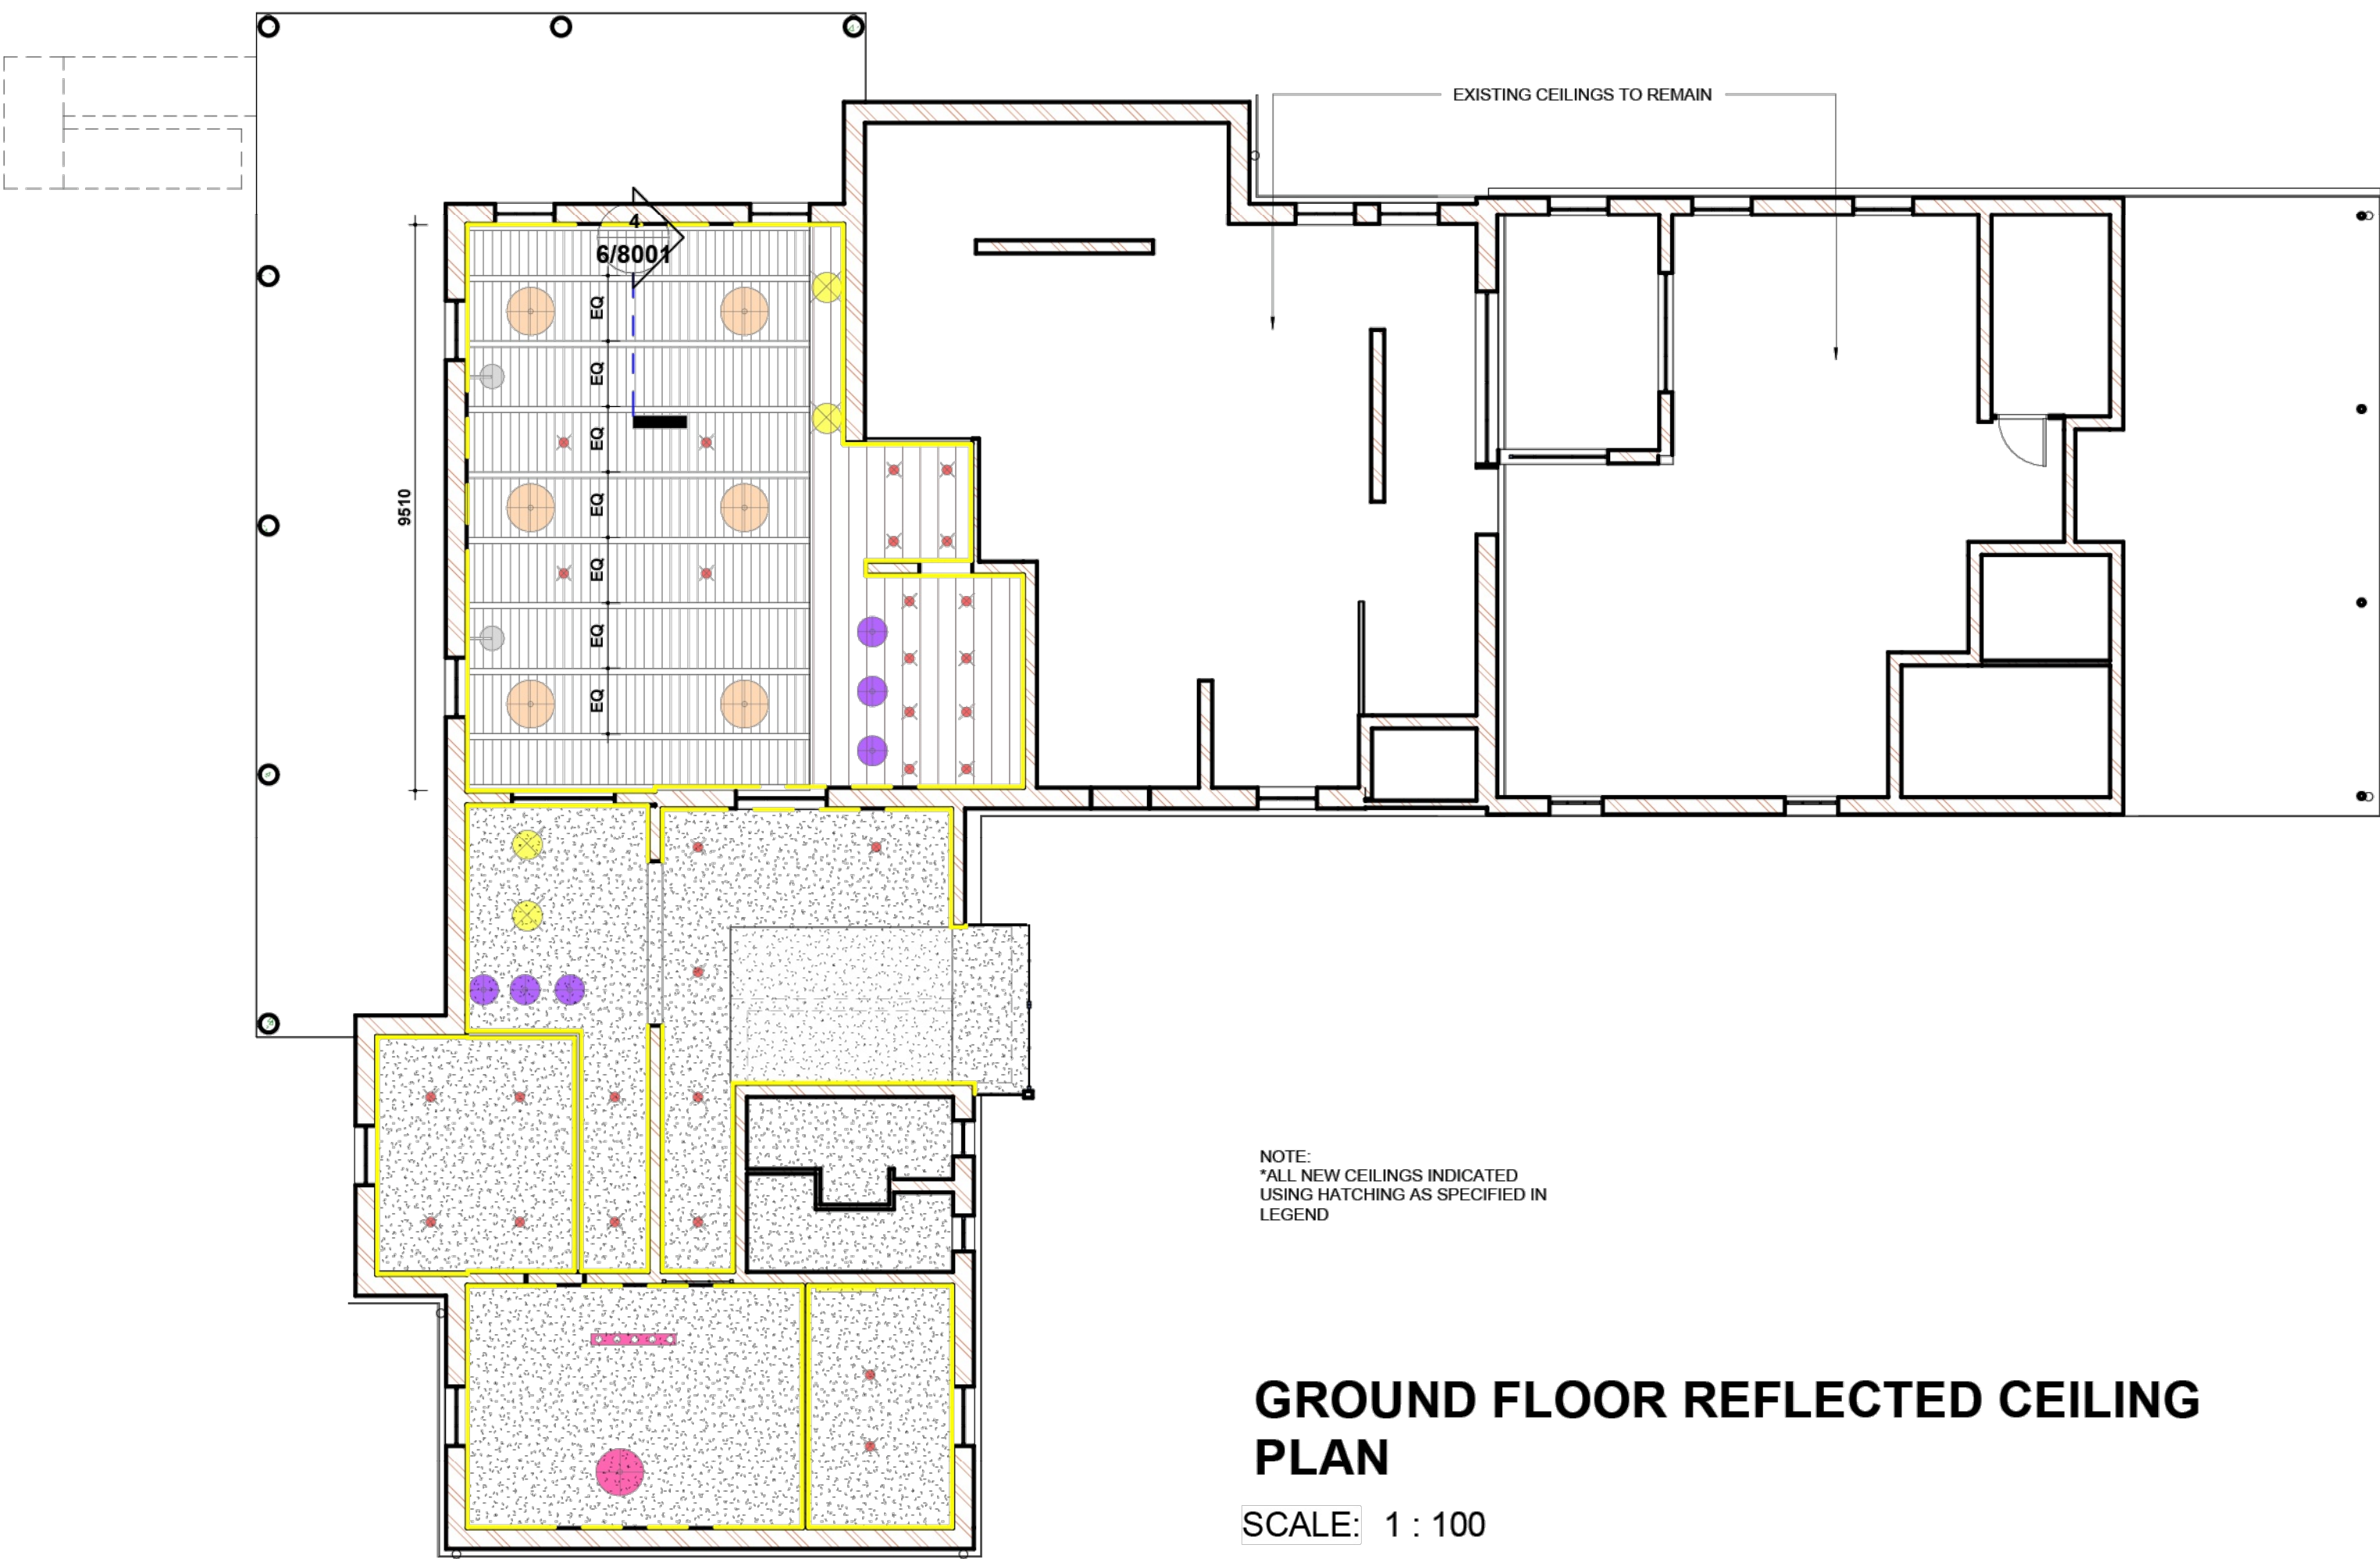

GROUND FLOOR REFLECTED CEILING PLAN

SCALE: 1 : 100

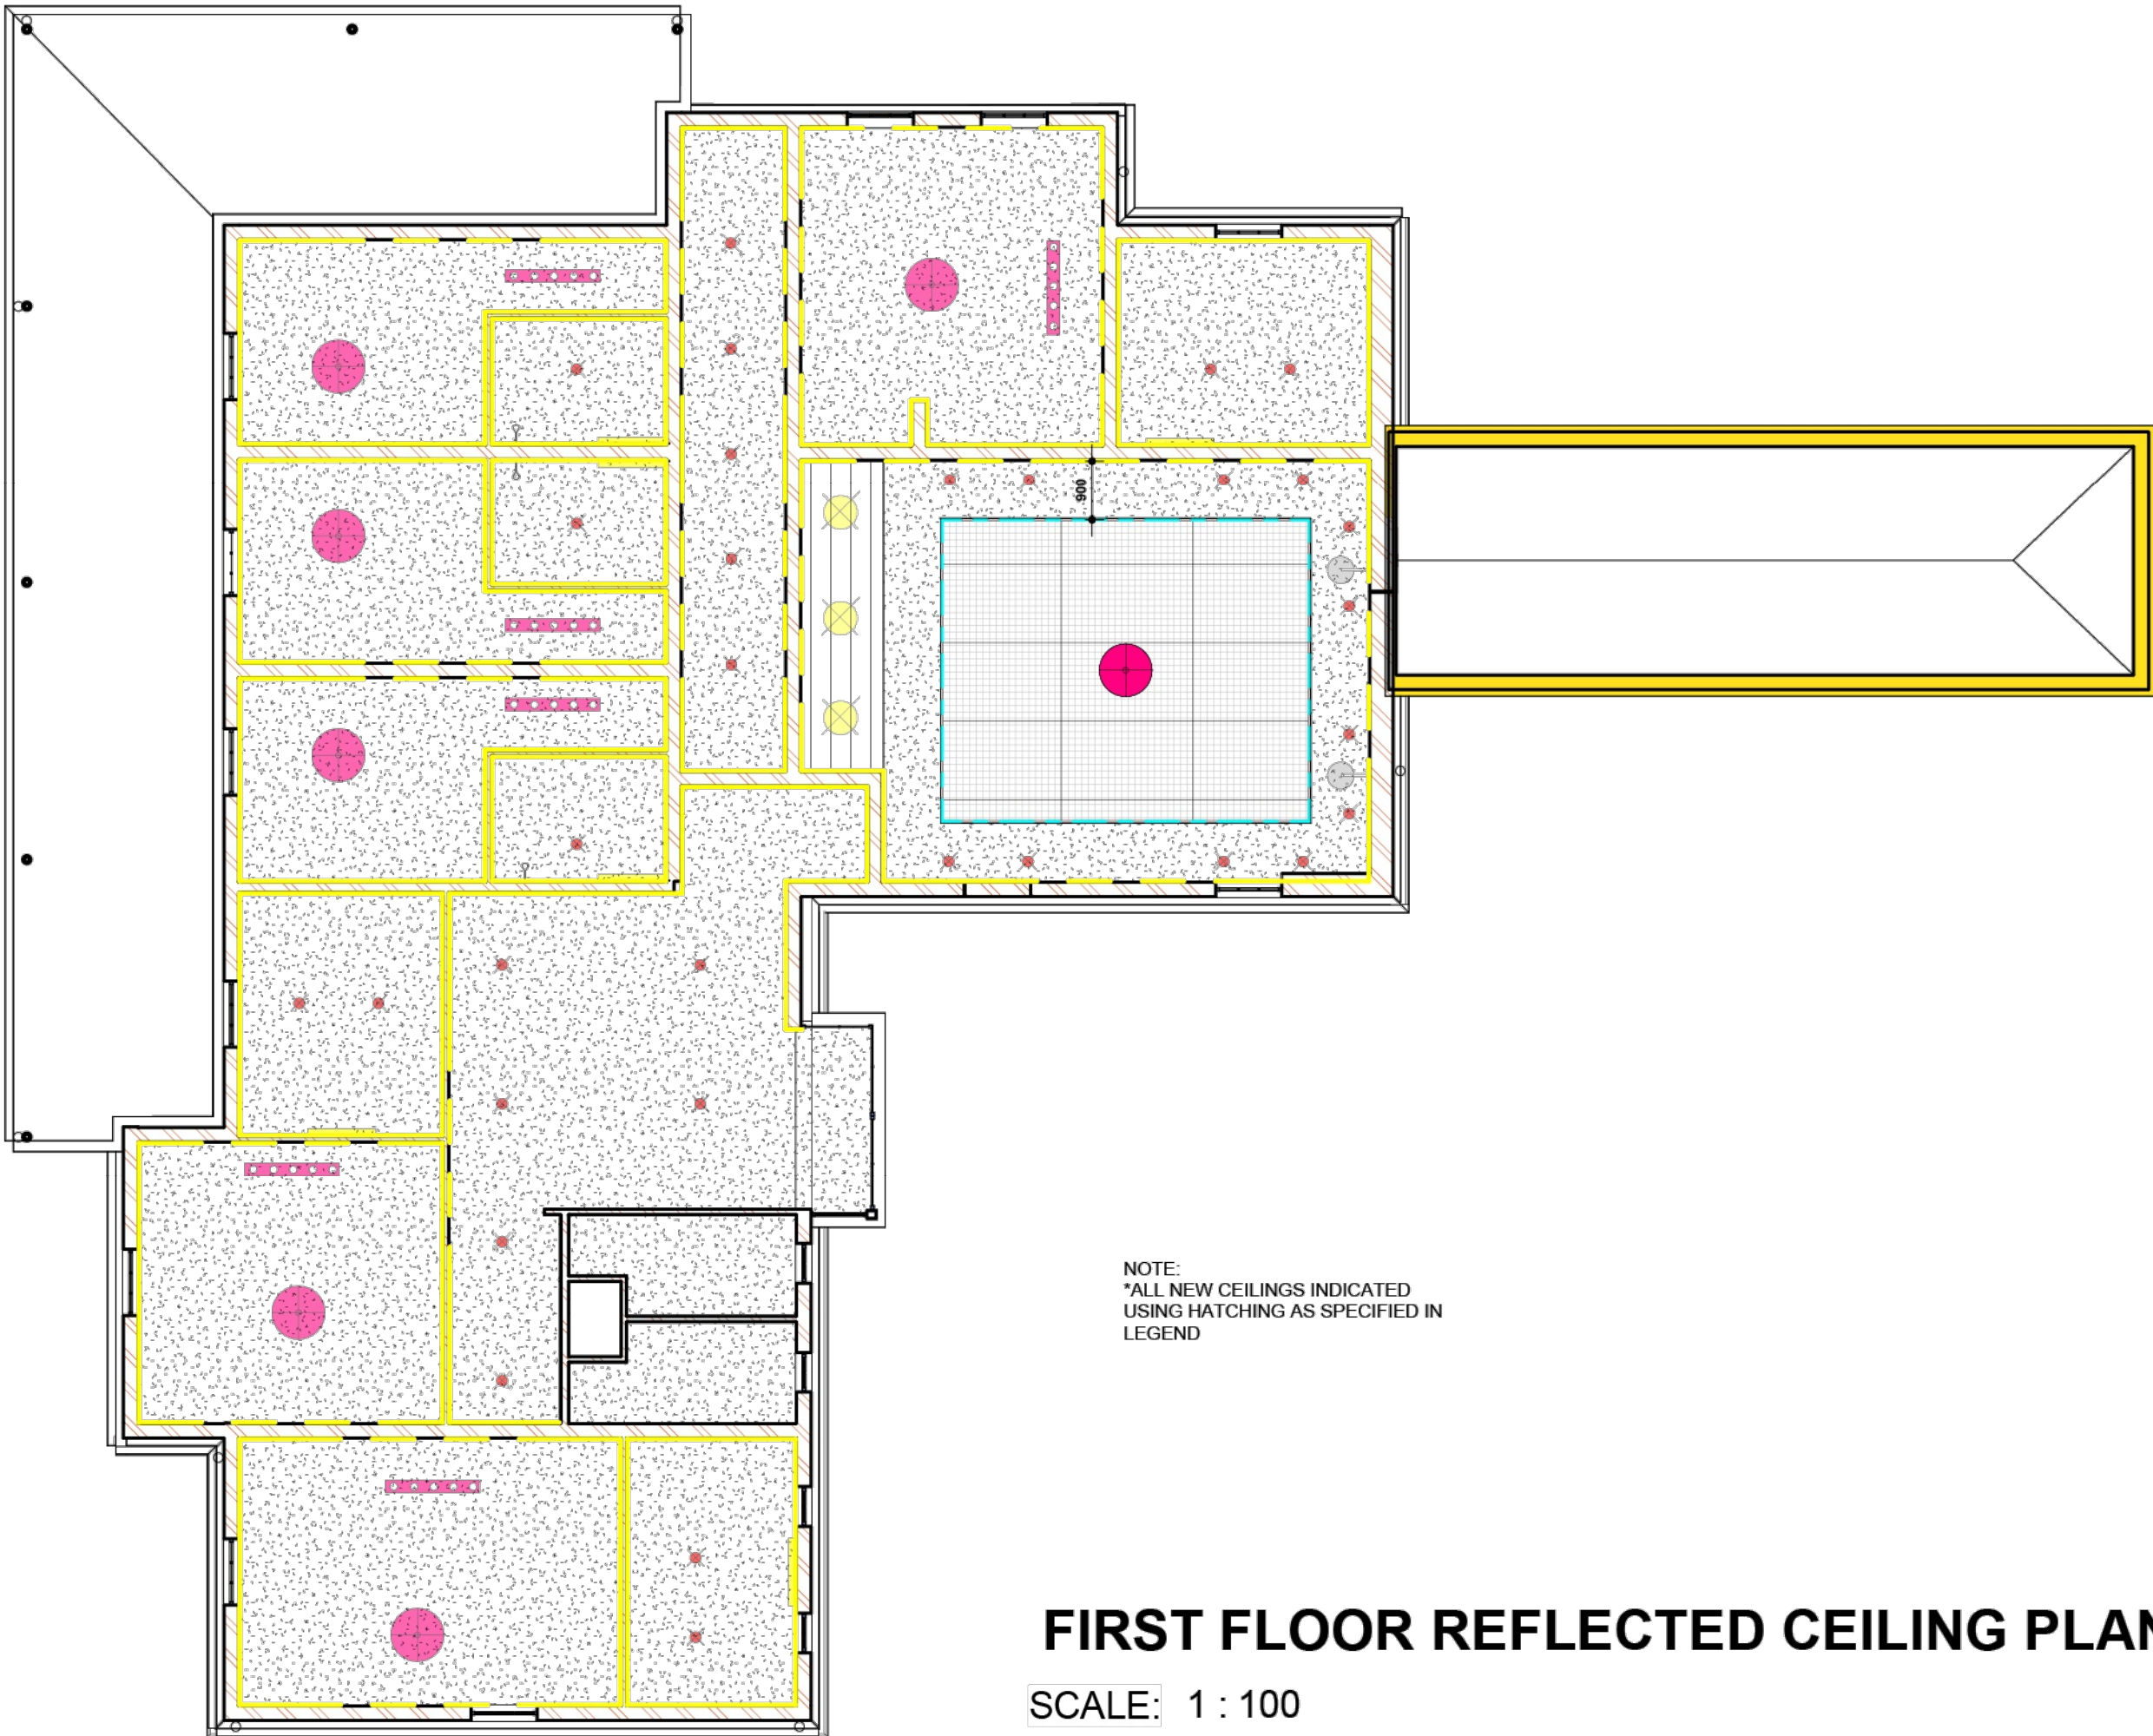

FIRST FLOOR REFLECTED CEILING PLAN

SCALE: 1 : 100

| CORNICE LEGEND |        |                                                              |
|----------------|--------|--------------------------------------------------------------|
| PROFILE        | SYMBOL | SPECIFICATION                                                |
|                |        | SUPPLIER: MR CORNICE<br>TYPE: EMERALD CORNICE<br>SIZE: 140mm |

| SPECIAL LIGHTING LEGEND |        |                                                                                                                                             |                   |
|-------------------------|--------|---------------------------------------------------------------------------------------------------------------------------------------------|-------------------|
| CODE                    | SYMBOL | SPECIFICATION                                                                                                                               | LOOK & FEEL IMAGE |
| SL 1                    |        | Recessed Downlighters<br>Die-cast aluminium downlight - non tilt - white complete with gu10 lampholder - dimensions: 80 x h25 - cut out: 65 |                   |
| SL 2                    |        | Wall mounted LED track spot<br>Wall mounted slim track black complete with live end and end cap - 3m                                        |                   |
| SL 3                    |        | Feature Pendant- Circular<br>Black wire hat pendant complete with 1500mm suspension - diameter tbc                                          |                   |
| SL 4                    |        | Surface Mounted LED strip light<br>In ceiling<br>Plastic cover flush with ceiling<br>Surface mounted 17x15 extrusion and diffuser           |                   |
| SL 5                    |        | Surface Mounted Downlighters<br>Surface mounted white gu10 downlight -height: 115 x diameter: 85                                            |                   |
| SL 6                    |        | Feature Pendant- Circular<br>Satin gold pendant with opal white glass - fitting height: 201cm; fitting width: 34cm; glass diameter tbc      |                   |
| SL 7                    |        | Surface mounted Track spotlights<br>Surface mounted slim track black complete with live end and end cap - 2m                                |                   |
| SL 8                    |        | Feature Pendant- Circular<br>Matte black pendant with opal white glass - fitting height: 201cm; fitting width: 34cm; glass diameter tbc     |                   |
| SL 9                    |        | Wall mounted reading light (Brass)<br>Brass picture light - 12w 3000k - height: 12cm; length: 67.5cm; depth: 21cm                           |                   |

NOTE:

IMAGES PROVIDE THE GENERAL LOOK AND FEEL ONLY, LOCAL SAMPLES TO BE APPROVED BY DESIGNERS, BULB SPECIFICATIONS TO BE CONFIRMED BY ELECTRICAL ENGINEER.

LIGHT POSITIONS ARE INDICATIVE, LIGHTING QUALITY, LIGHT FIXTURE QUANTITIES AND SPECIFICATIONS TO BE CONFIRMED BY ELECTRICAL ENGINEER / LIGHTING SUPPLIER.

SPECIAL LIGHTING EXACT POSITIONS TO BE COORDINATED ON SITE ONCE PROPER ON-SITE DIMENSIONS CAN BE TAKEN.

ALL CEILING REINFORCING AS PER STRUCTURAL ENGINEER'S SPECIFICATION, REFER TO NOTES ON DRAWINGS.

| CEILING FINISH LEGEND |      |                                                                                  |
|-----------------------|------|----------------------------------------------------------------------------------|
| SYMBOL                | CODE | SPECIFICATION                                                                    |
| CF 1                  |      | TIMBER PANEL HARDWOOD CEILING<br>IN ACCORDANCE WITH MANUFACTURERS SPECIFICATIONS |
| CF 2                  |      | 9mm FLUSH PLASTERED CEILING @2790mm AFFL<br><br><b>Keynote:</b> CLG-510(12.14):  |
| CF 3                  |      | TONGUE AND GROVE CEILING 140mm x 13mm WITH HORIZONTAL PINE BEAMS                 |
| CF 4                  |      | RIGITONE ACOUSTIC LAYED IN CEILING                                               |

CEILING NOTES

ALL EDGES AND BETWEEN DIFFERENT CEILINGS, OR WHERE CEILING TILES CHANGE DIRECTION, TO RECEIVE A 20mm SHADOWLINE  
TRIM AS PER SPECIALIST.  
CEILING SPECIALIST TO ALLOW FOR CEILING MOVEMENT JOINTS IN FLUSH PLASTERED CEILINGS AT EVERY INTERSECTION  
BETWEEN DIFFERENT CEILING TYPES, AS WELL AS WHERE CEILINGS CHANGE DIRECTION, OR STEP AROUND WALLS/CORNERS.

FOR INSTANCES WHERE VERTICAL FLUSH PLASTERED CEILING AND BEAMS MEET:  
ADD A 20mm SHADOWLINE TO NEATLY CONNECT BEAMS AND CEILING.

DRAWING REFERENCE

| Drawing No. | Drawing Title |
|-------------|---------------|
|             |               |

NOTES

LEGEND

DRAWING AMENDMENTS

| No. | Amendment    | Date      | Appr. |
|-----|--------------|-----------|-------|
| 0   | FOR APPROVAL | JULY 2026 | TR    |

|                                 |                          |
|---------------------------------|--------------------------|
| Designed<br><b>L WELGEMOED</b>  | Date<br><b>JULY 2026</b> |
| Checked<br><b>T RAPHALALANI</b> | Date<br><b>JULY 2026</b> |
| Drawn<br><b>L WELGEMOED</b>     | Date<br><b>JULY 2026</b> |
| Client appr.                    | Date                     |

Consultant

**NEMORANGO**  
CONSULTING  
ENGINEERS

CIVIL ENGINEERS, HYDROGEOLOGISTS  
& PROJECT MANAGERS

(015) 295 2023 FAX : (015) 295 2024  
10A HANS VAN RENSBURG  
POLKOWANE 0699

Client Name :



Contract No.

Proj Name :

IKHALA TVET COLLEGE

Drawing Title

REFLECTED CEILING LAYOUT

|             |                       |
|-------------|-----------------------|
| Proj Number | Drawing No.<br>6/6000 |
|-------------|-----------------------|

|                |              |
|----------------|--------------|
| Scale<br>1:100 | Rev No.<br>0 |
|----------------|--------------|